
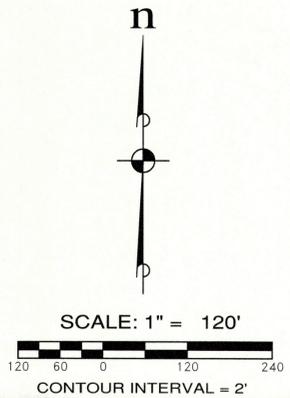


File: \\vermont\ENGR\ESM-JOB\998\883\022\washba\04-06.dwg  
 Plotted By: jeff hino  
 Plotted: 9/7/2022 1:54 PM

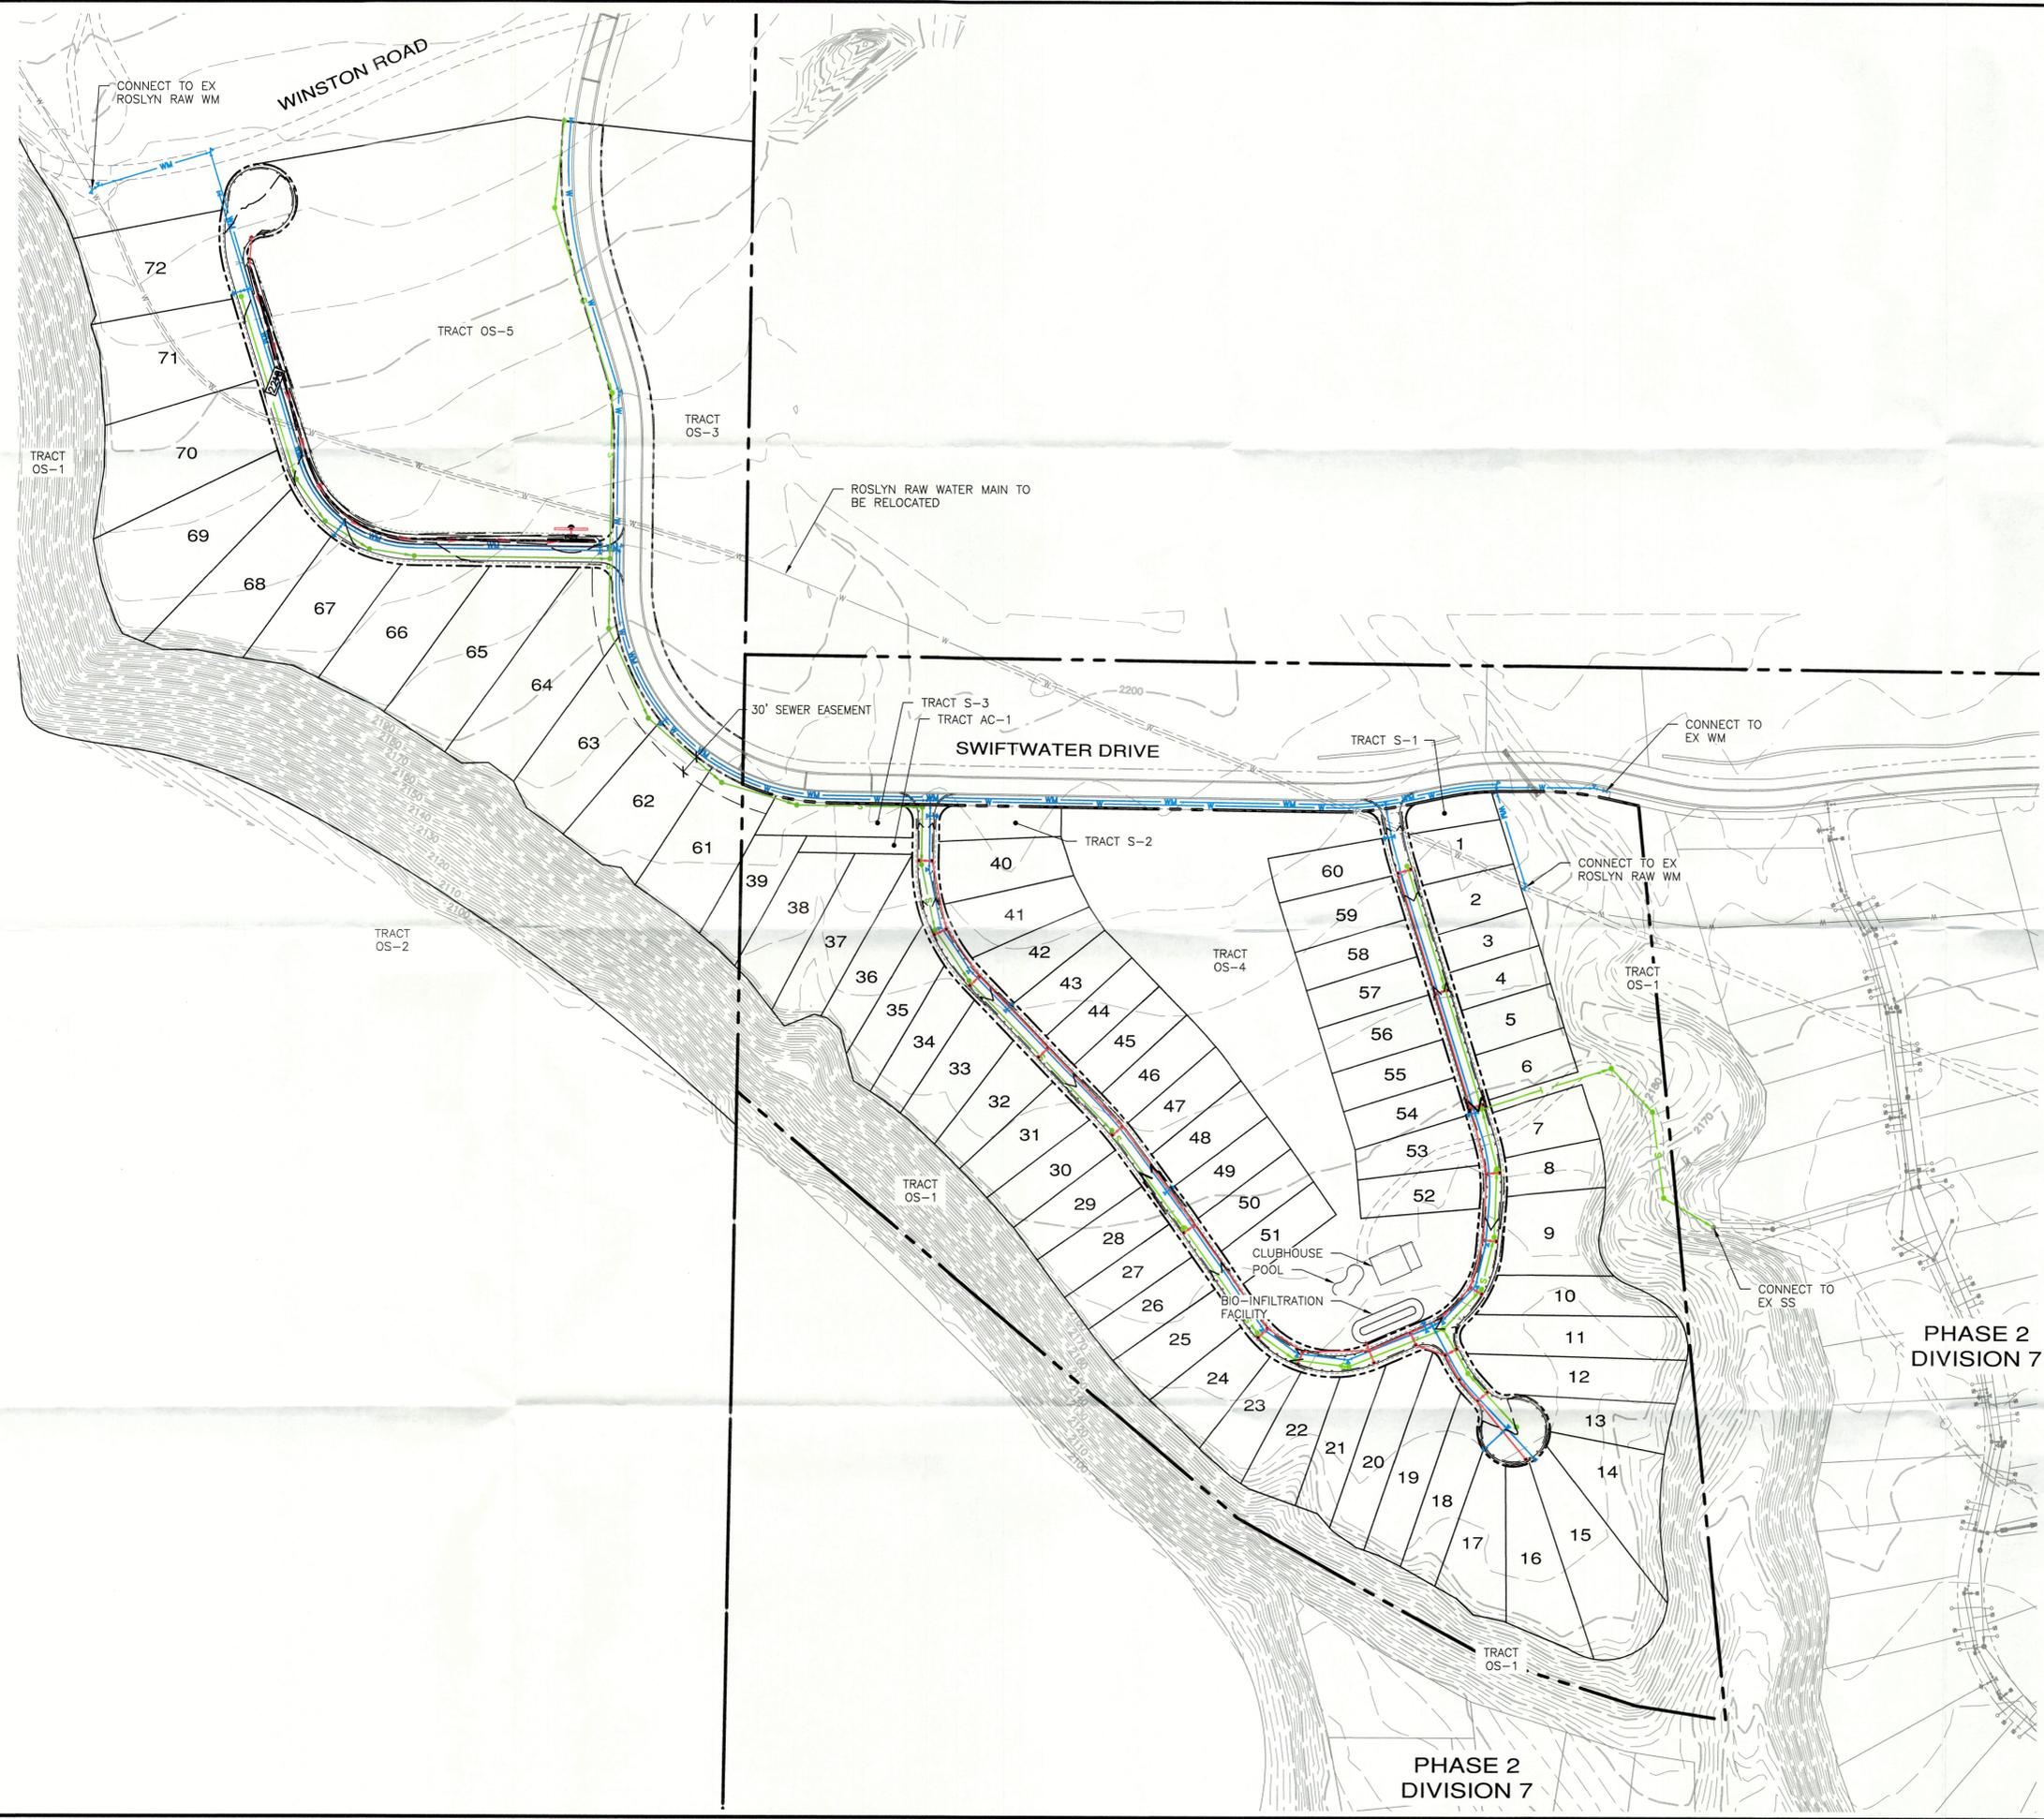

- LEGEND**
- STORM DRAINAGE
  - 12" SANITARY SEWER MAIN
  - 8" SANITARY SEWER MAIN
  - 8" DOMESTIC WATER MAIN
  - 18" DOMESTIC WATER MAIN
  - RELOCATED 16" ROSLYN RAW WATER MAIN
  - EX 16" ROSLYN RAW WATER MAIN
  - SANITARY SEWER MANHOLE
  - FIRE HYDRANT
  - STORM DRAINAGE FLOW PATH
  - SANITARY SEWER CLEANOUT
  - CATCH BASIN
  - -2056- EXISTING MINOR CONTOUR
  - -2060- EXISTING MAJOR CONTOUR

REVISIONS		
NO.	DESCRIPTION/DATE	BY

**ESM CONSULTING ENGINEERS, LLC**  
 33400 8th Ave S, Suite 205  
 Federal Way, WA 98003  
 FEDERAL WAY (206) 839-4113  
 EVERETT (425) 297-8900

www.esmcivil.com

Civil Engineering  
 Public Works

Land Surveying  
 Project Management

Land Planning  
 Landscape Architecture

SUNCADIA RESORT LLC  
**PHASE 2 DIVISION 8**  
 CONCEPTUAL UTILITY PLAN  
 KITTITAS COUNTY WASHINGTON

JOB NO.:	998-883-022
DWG. NAME:	EN-06
DESIGNED BY:	LGB
DRAWN BY:	OFF
CHECKED BY:	
DATE:	09/09/2022
DATE OF PRINT:	