


File: \\Esm\eng\ESM-085\988\746\017\enbsh\EN-03.dwg  
 Plotted: 3/19/2018 2:46 PM  
 Plotted By: Jeff Hino

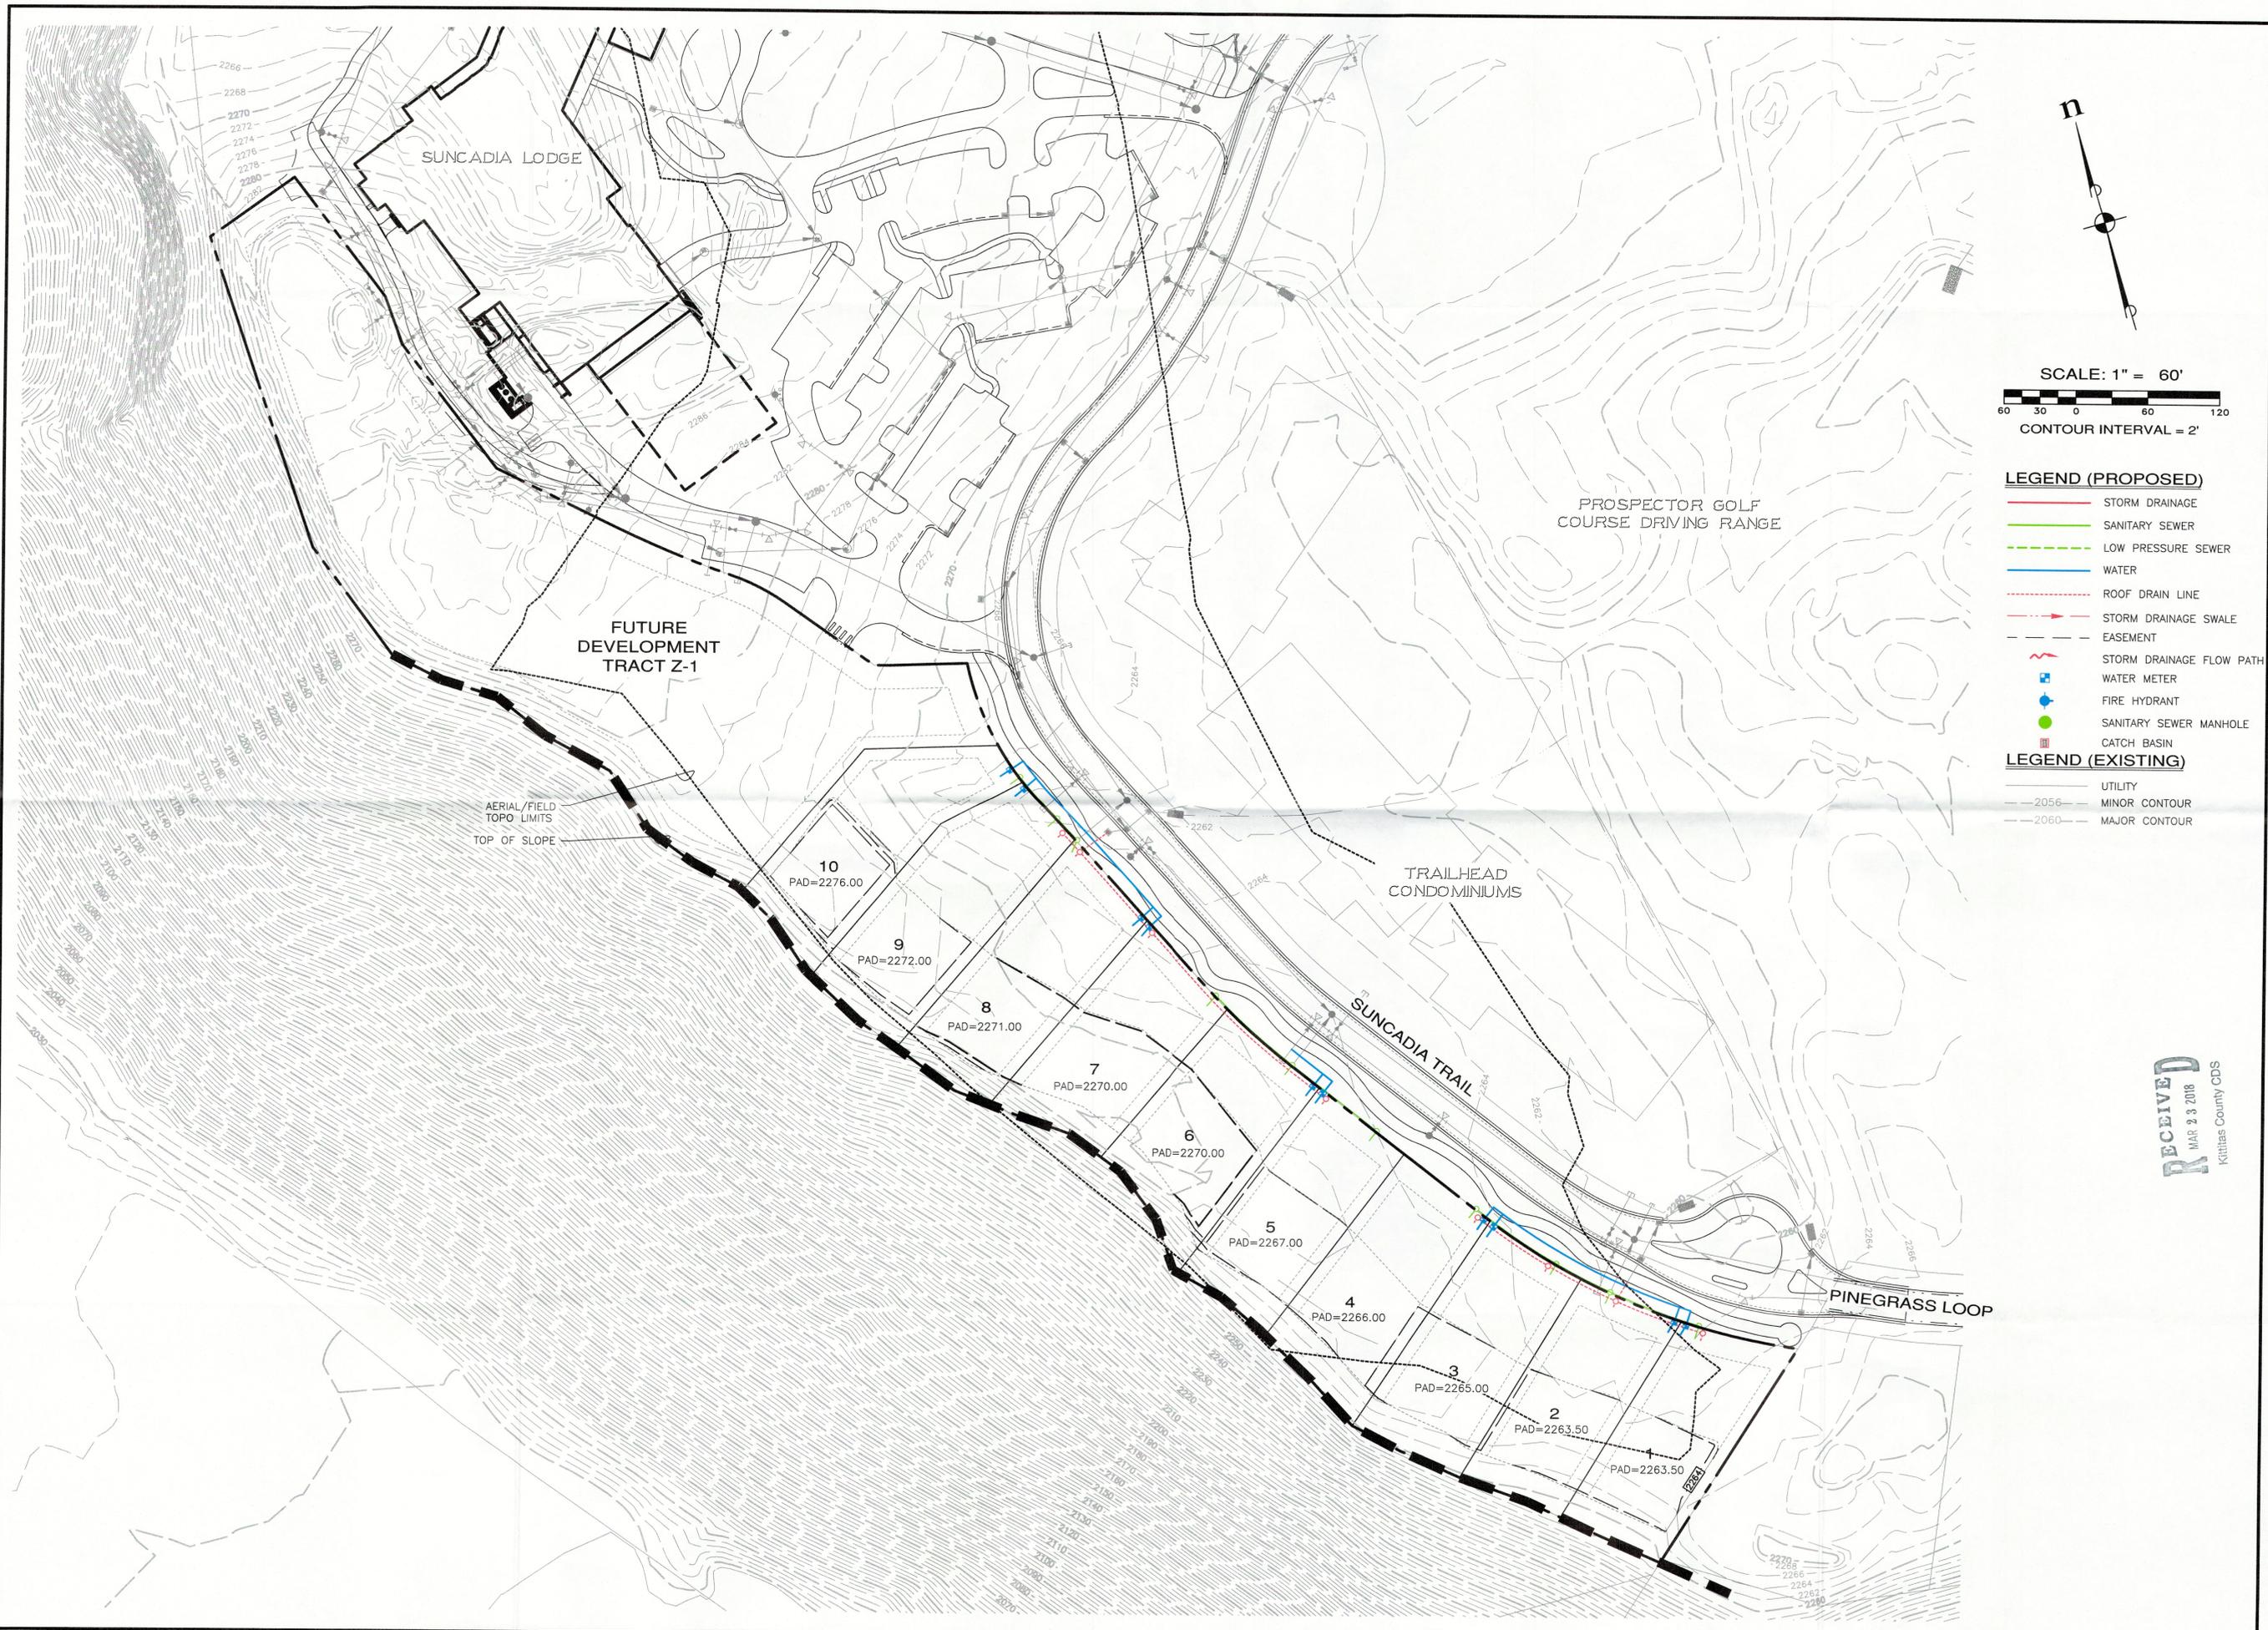

n

SCALE: 1" = 60'

CONTOUR INTERVAL = 2'

- LEGEND (PROPOSED)**
- STORM DRAINAGE
  - SANITARY SEWER
  - - - LOW PRESSURE SEWER
  - WATER
  - - - ROOF DRAIN LINE
  - - - STORM DRAINAGE SWALE
  - - - EASEMENT
  - ~ STORM DRAINAGE FLOW PATH
  - WATER METER
  - FIRE HYDRANT
  - SANITARY SEWER MANHOLE
  - CATCH BASIN
- LEGEND (EXISTING)**
- UTILITY
  - - - MINOR CONTOUR
  - - - MAJOR CONTOUR

**RECEIVED**  
 MAR 23 2018  
 Kittitas County ODS

REVISIONS		
NO.	DESCRIPTION/DATE	BY

**ESM CONSULTING ENGINEERS, LLC**  
 33400 8th Ave S, Suite 205  
 Federal Way, WA 98003  
 (206) 835-9910  
 (206) 244-9900

www.esmcivil.com  
 Civil Engineering | Land Surveying  
 Public Works | Project Management  
 Land Planning | Landscape Architecture

**NEW SUNCADIA LLC**  
**PHASE 1 DIVISION 15**  
 COMPOSITE UTILITY PLAN

WASHINGTON  
 KITTITAS COUNTY

JOB NO.:	988-766-017
DWG. NAME:	EN-03
DESIGNED BY:	LGB
DRAWN BY:	JJH
CHECKED BY:	
DATE:	03/20/2018
DATE OF PRINT:	

**EN-03**

1 OF 1 SHEETS